

- NOTE

1. CANOPY TBC AFFL
2. PUBLIC SECURITY LIGHTING TO BE ENERGIZED DURING HOURS OF DARKNESS
3. PUBLIC BUILDING LIGHTING TO BE ENERGIZED AS DETAILED ON CONTROL SCHEMATIC DRAWING E02
4. ALL APPLICABLE SIGNAGE TO BE ILLUMINATED AS DETAILED CONTROLS SCHEMATIC DRAWING E02
5. ALL SERVICES SHALL BE CONCEALED WHERE POSSIBLE, EITHER WITHIN FLOOR, WALL OR CEILING VOIDS
6. ALL APPLICABLE BUILDING FEATURE LIGHTING TO BE ENERGISED AS DETAILED ON CONTROLS SCHEMATIC DRAWING E02

COPYRIGHT
This drawing is copyright and may not be altered, reproduced or used other than for the Contract Works for which it is issued without written permission.

STATUS OF DRAWING
The purpose of this drawing when issued as a Tender Drawing is to enable tenderers to interpret correctly the design and submit competitive tenders for the Works.

TENDER
A Tender Drawing whether original or amended shall not be used as an Installation Drawing except under the terms contained in the Conditions of Tender.

WARNING
Do not scale this drawing. Verify all dimensions and structural details on site.
If in doubt, ask before acting.

RELATED DOCUMENTS
Read this drawing in conjunction with the appropriate Specification(s).

CHECKING
This drawing has been generated using a Computer Drafting System. As the system generates a new drawing at each revision, only the latest edition shall be

[illegible]

Revision	Revision Notes

[illegible][illegible][illegible][illegible][illegible][illegible]

**DRAWING BASED ON:
SK2A 07-03-2019 FOR PLANNING
ONLY**



Halsall

Electrical

Oak Tree Court | Brookfield Drive | Cannock | Staffs | WS11 0JN

Tel: 01543 4065200 | Fax: 01543 4065222 | E-Mail: info@halsall-electrical.co.uk

Client:



Project:

WILM FOLKESTONE

WIMSTOLKSTIC

FRESH LOOK W


Drawing Title:

Electrical Services

BUILDING MOUNTED, FEATURE LIGHTING
AND ILLUMINATED SIGNAGE LAYOUT

Designed: J.T	CAD: S.G	Checked: J.T	Date: MAR'19
Scale: A0 @1:100		Project No.: 0000	
Drawing Number:			Revision:

E070

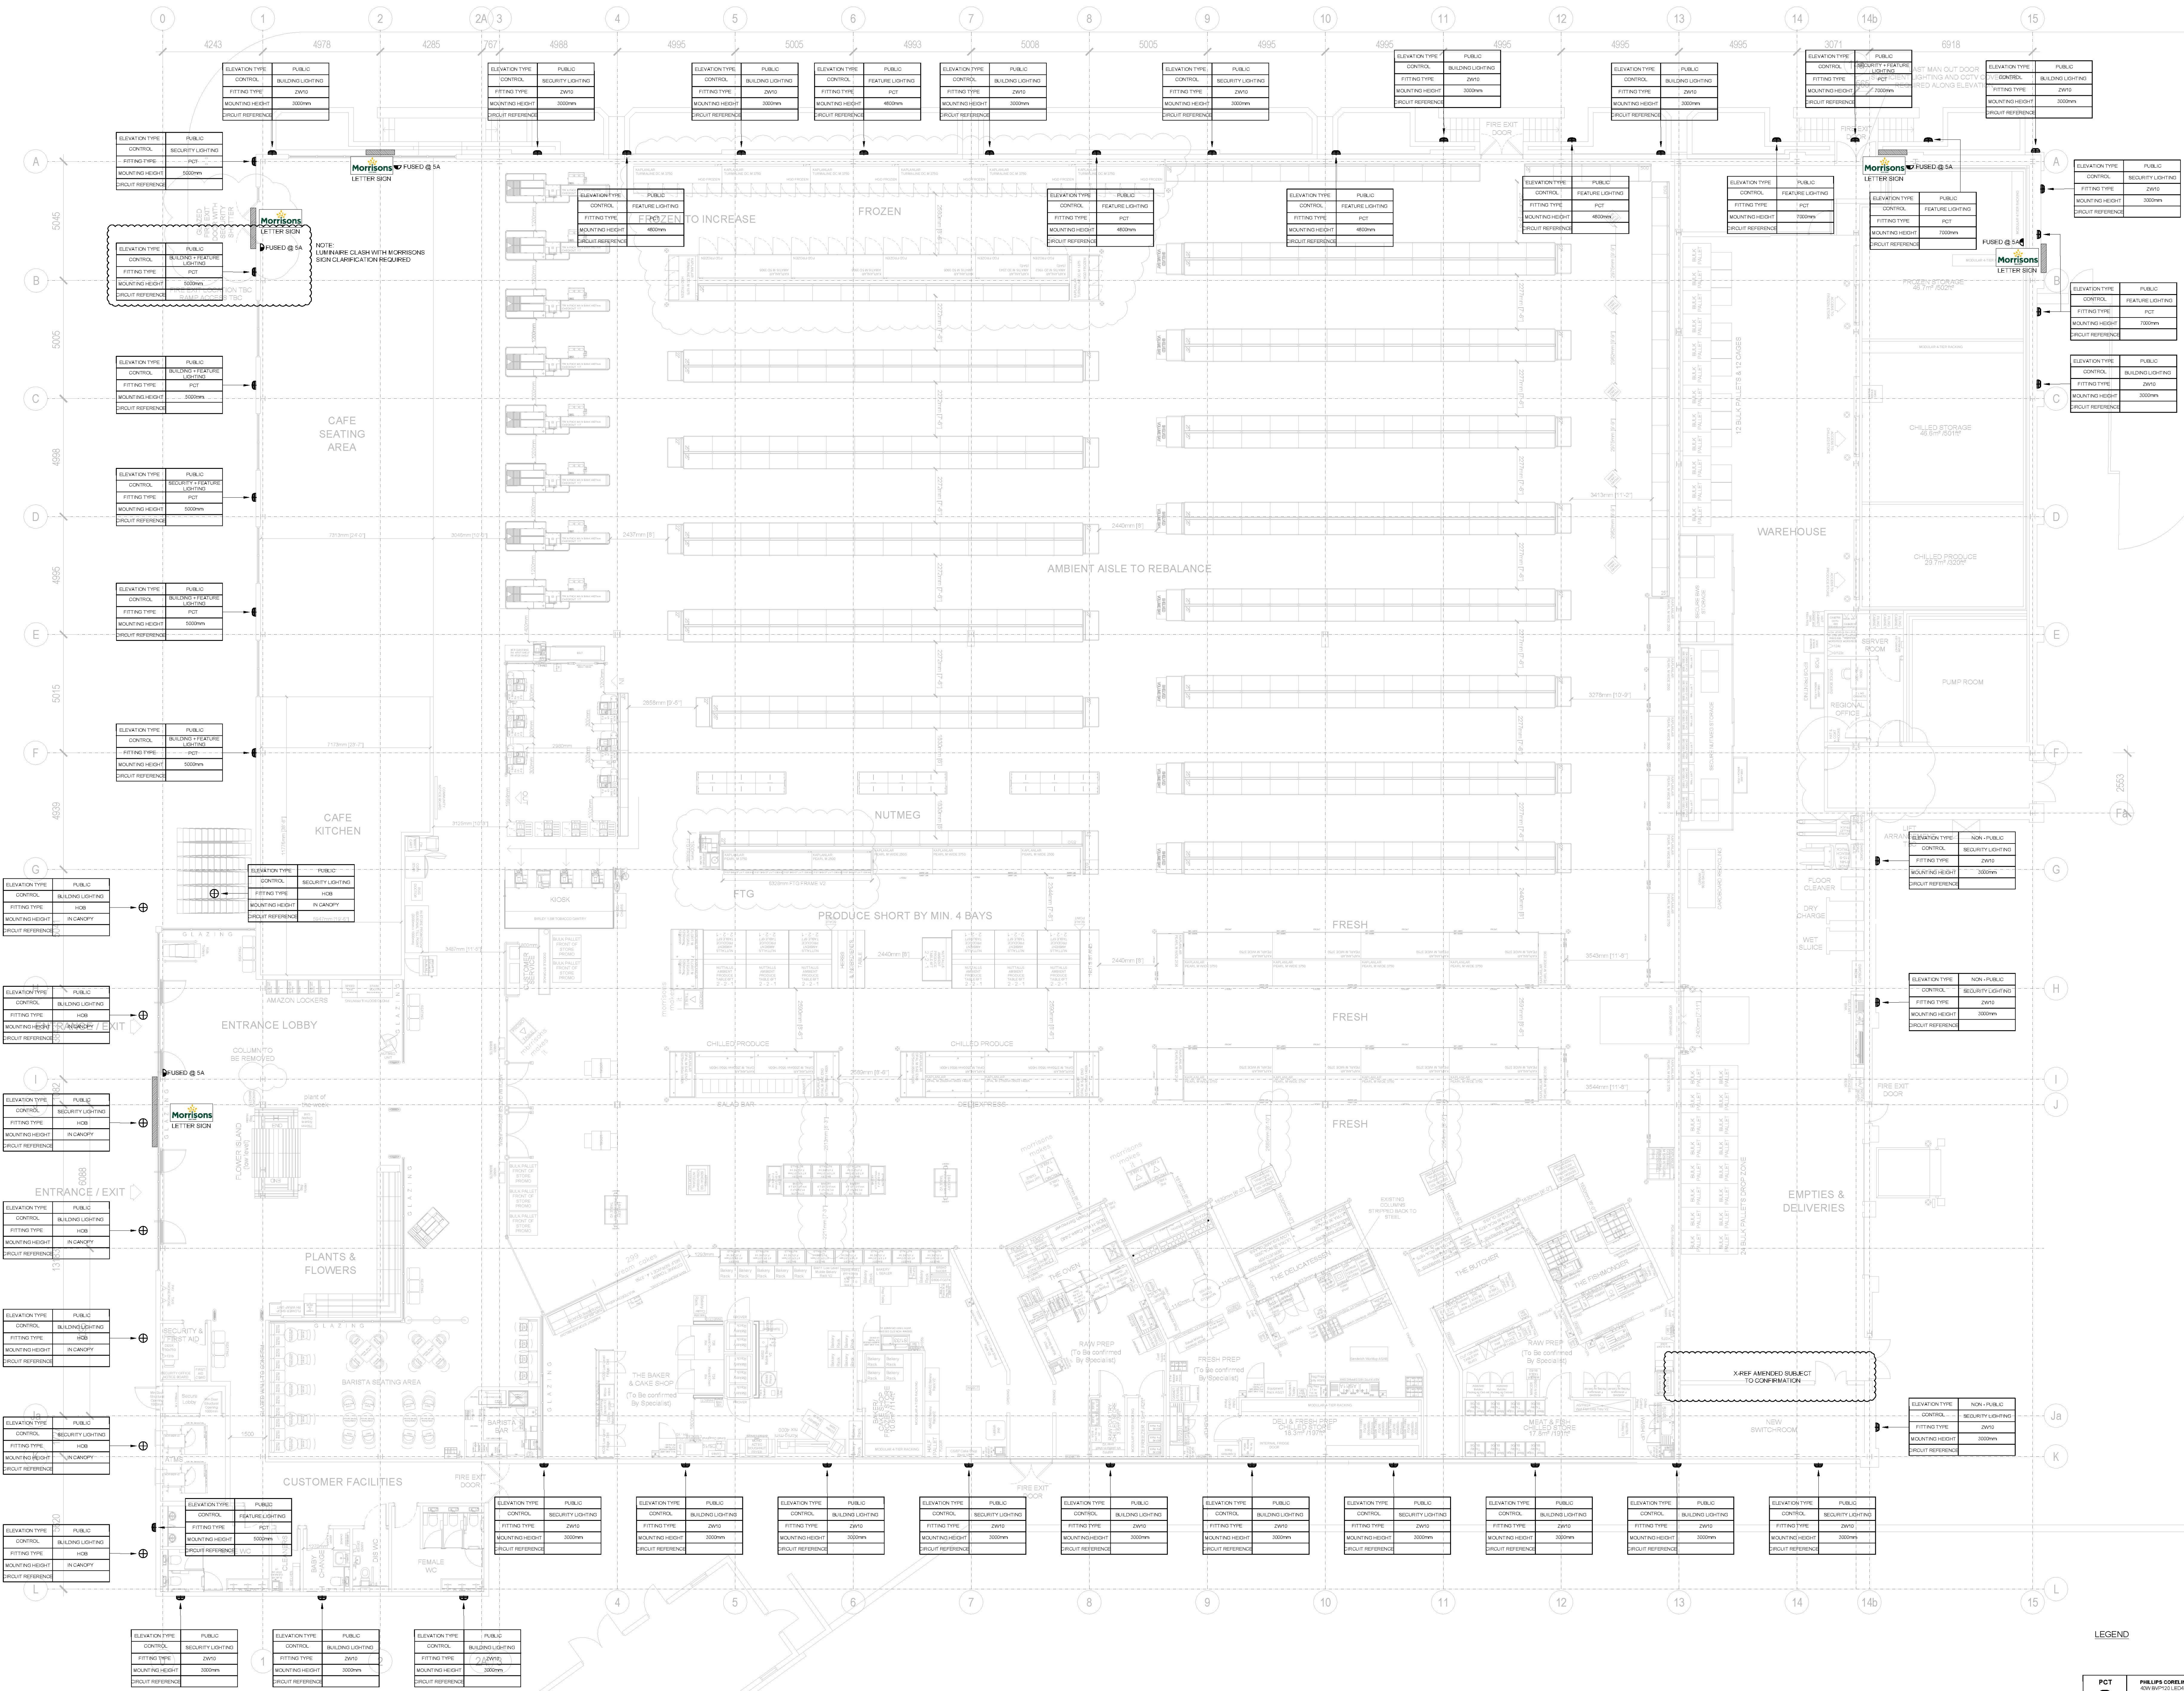

LEGEND

PCT 	PHILIPS CORELINE TMR FLOODLIGHT 40W IP23 LED 100MMx5 LED MODULE 4000K SYMMETRICAL IP65 COLOUR TEMP 4000K	40W	
HOB 	Hekaphane OBO LED RECESSED DOWNLIGHT , IP65 17W 250xM 4000K. FINISH GREY	17W	
ZW10 	HOLOPHANE DJERREA LED 16W, LED 1400LM (8000K) WALL MOUNTED CIRCULAR FITTING, FINISH GREY	14W	1400LM

MORRISONS LETTER SIGN

