


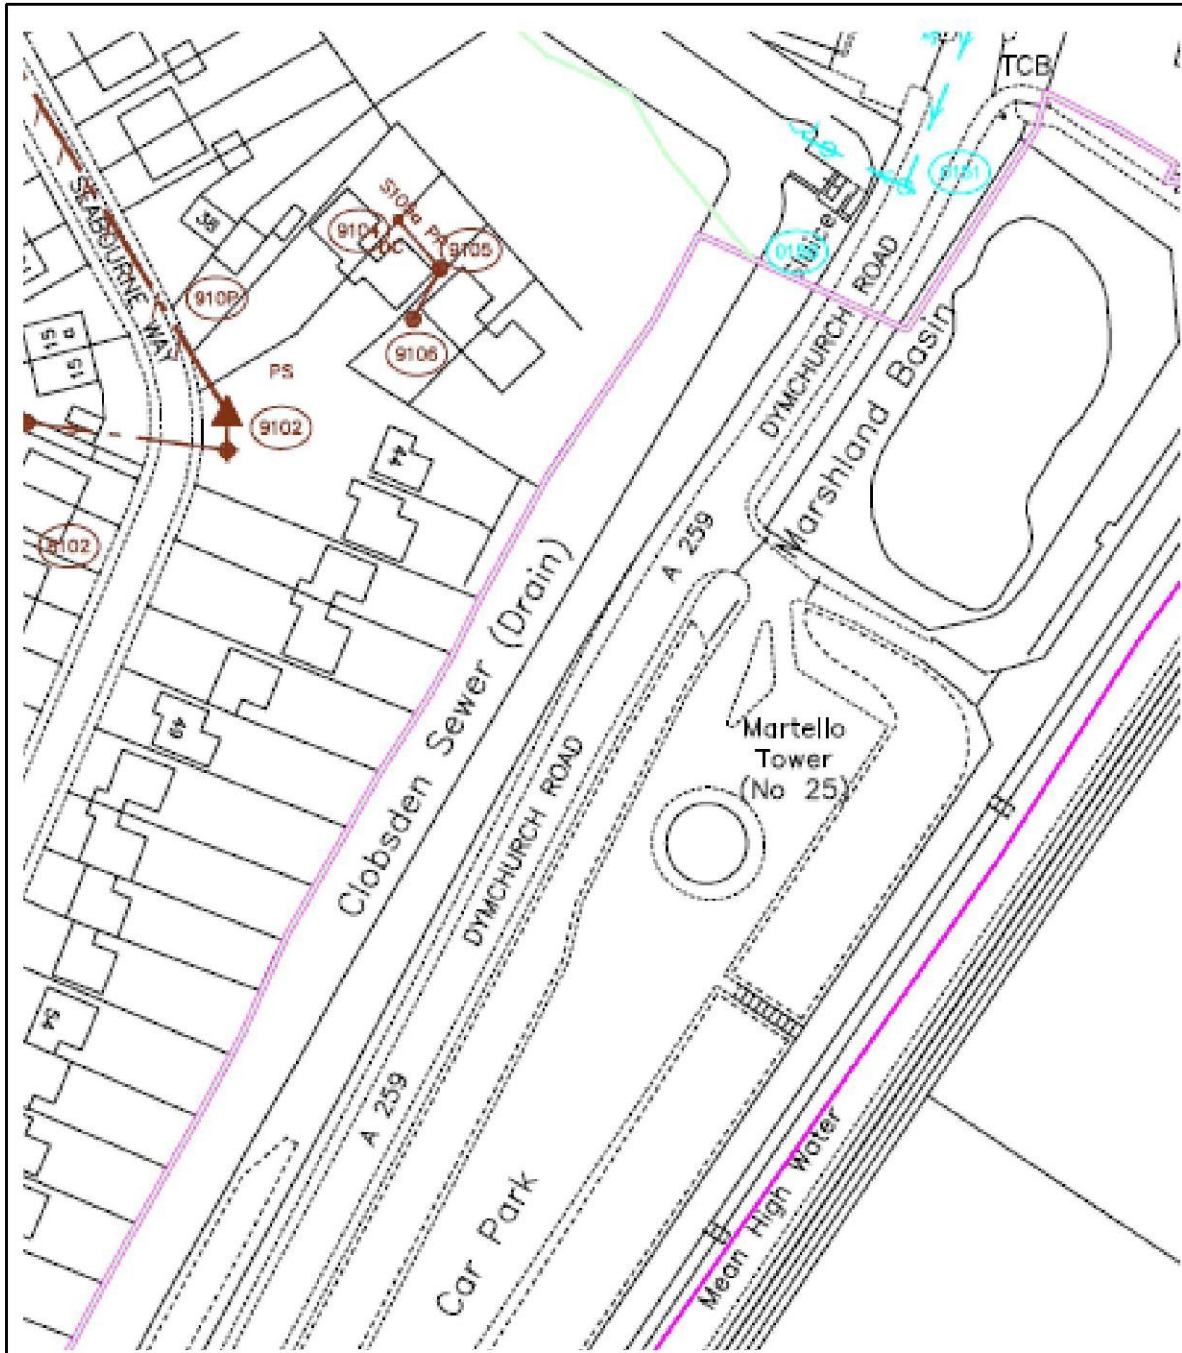


Map of sewers as obtained from Southern Water
scale 1:1250@A3



Indicates development boundary


Proposed Site Plan
scale 1:500@A3

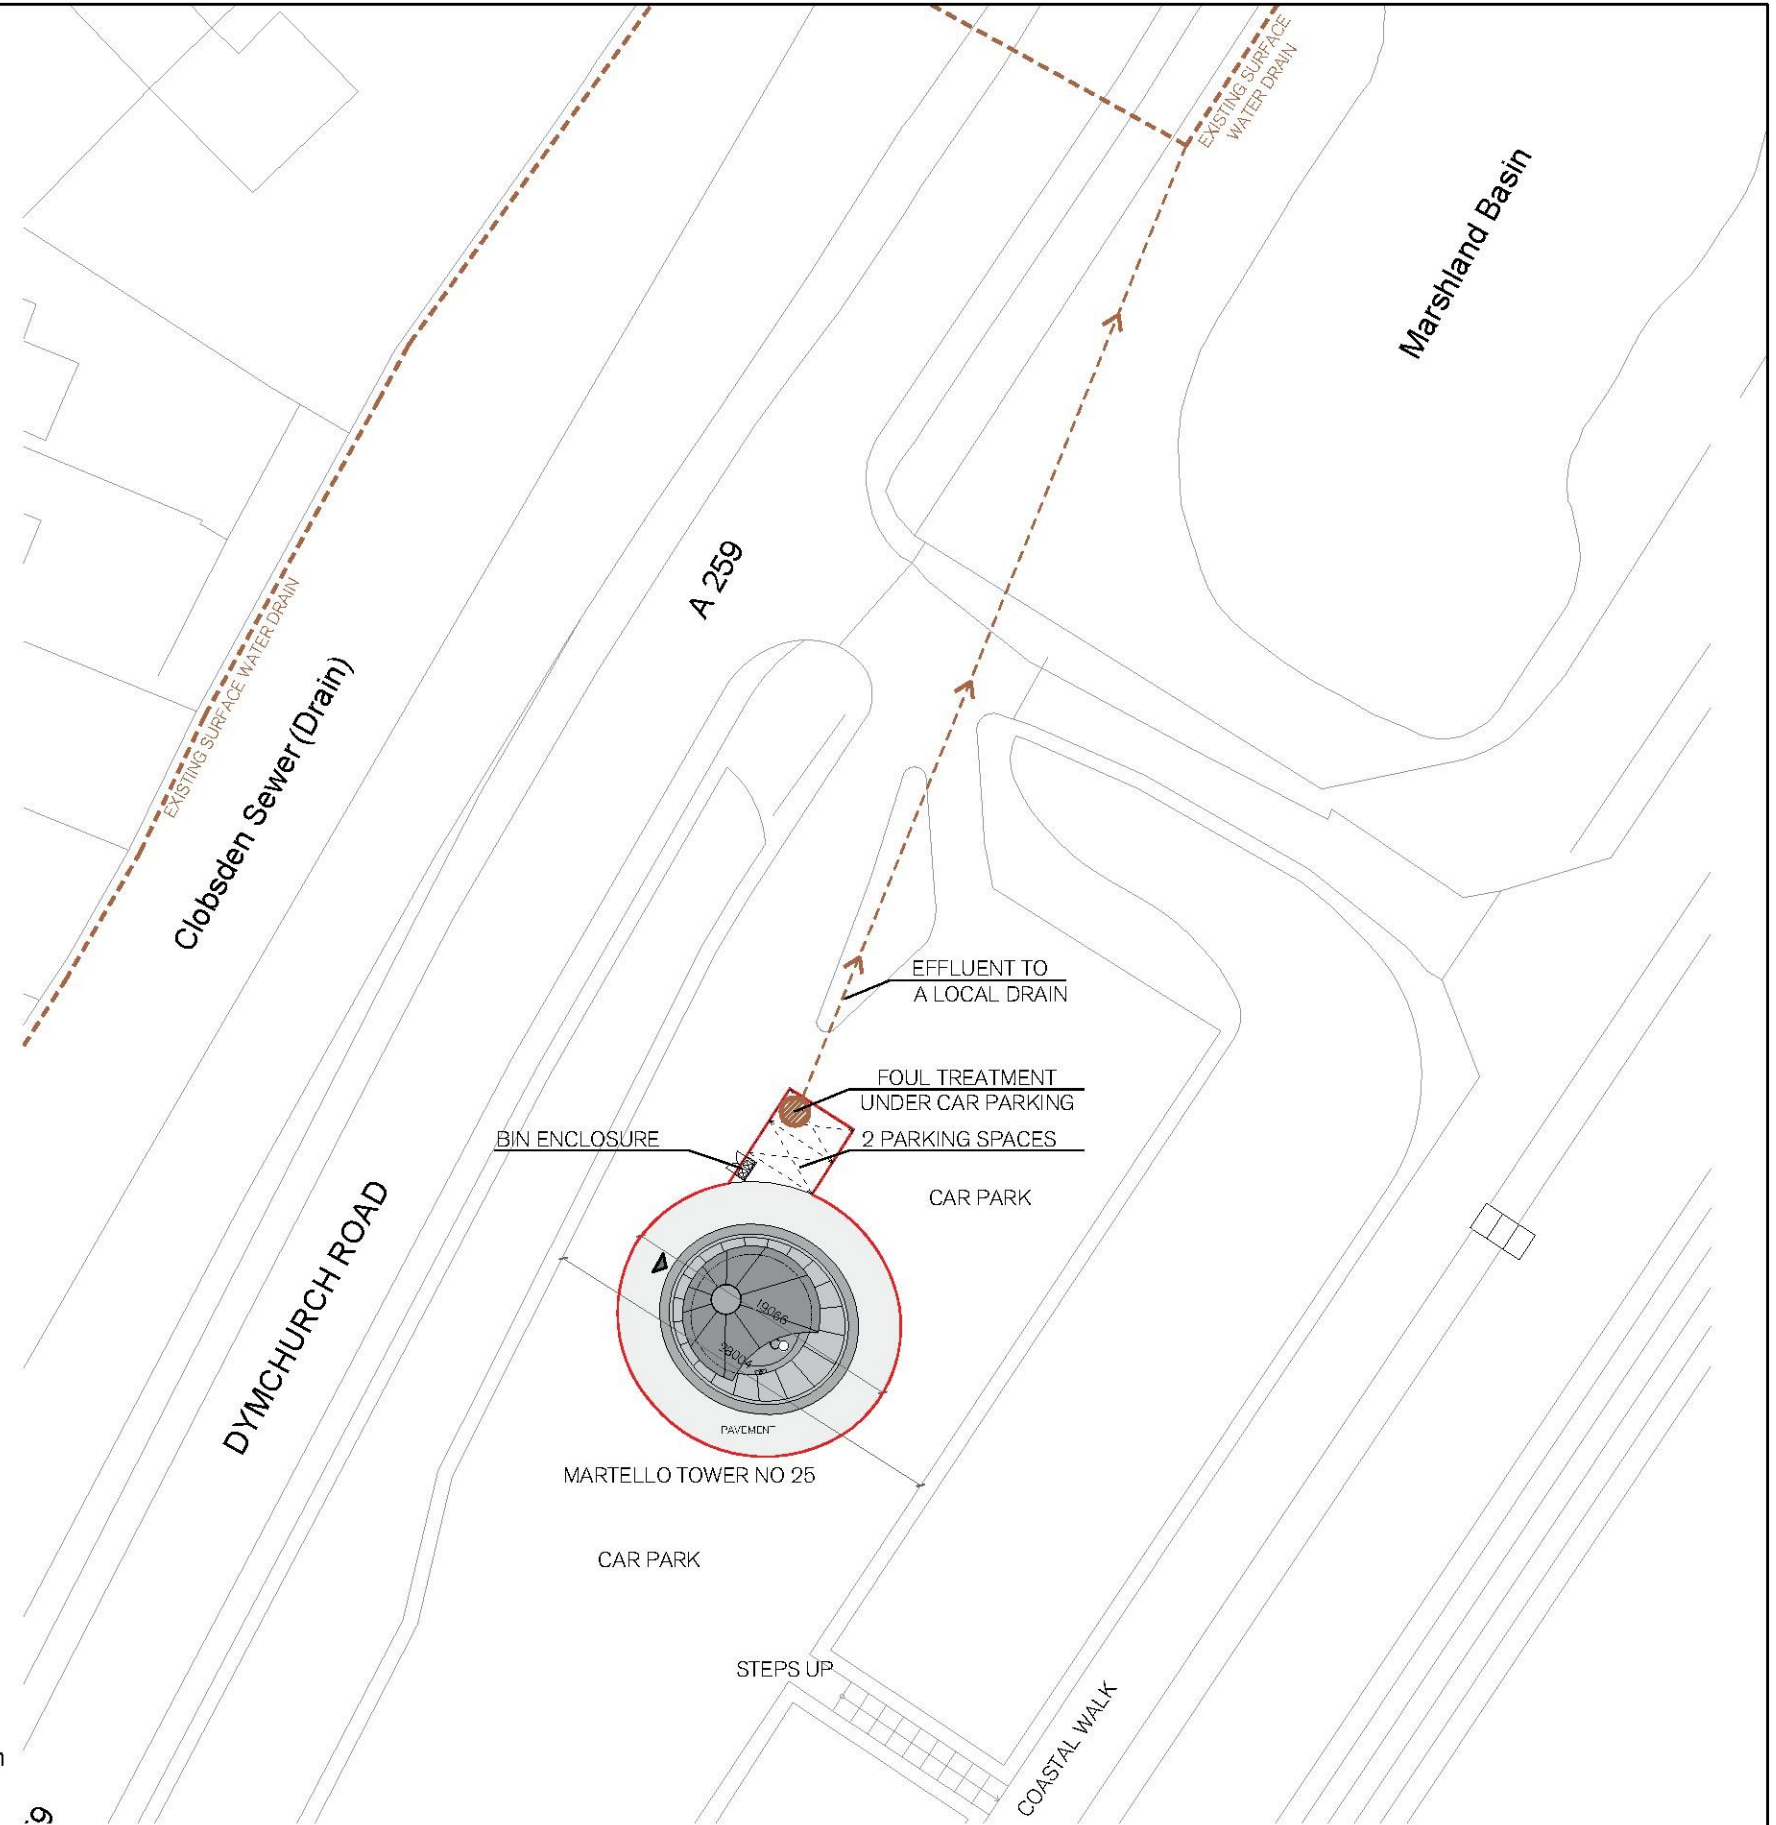

THIS DRAWING IS THE COPYRIGHT OF DUNN ARCHITECTS AND SHOULD NOT BE COPIED OR REPRODUCED WITHOUT WRITTEN CONSENT. ALL DIMENSIONS MUST BE CHECKED ON SITE. DO NOT SCALE OFF THIS DRAWING EXCEPT FOR PLANNING PURPOSES. THIS DRAWING MUST BE READ IN CONJUNCTION WITH THE SPECIFICATION OF WORKS. ALL WORKS MUST BE CARRIED OUT IN ACCORDANCE WITH THE STATUTORY AUTHORITIES.

CAD File:
0000

 Notes:



Revision	Date	Details	Revised By	Checked By
A	00/00/00	-	-	-

Project Name:
Martello Tower 25
Drawing Name:
Proposed Site Plan
Client:
Nicola Dealtry
Status:
Planning
Scale:
1/500@ A3

Date:
25/09/18
Drawn By:
ZS



Drawing Number:
00718-P00-100
Revision:
-