


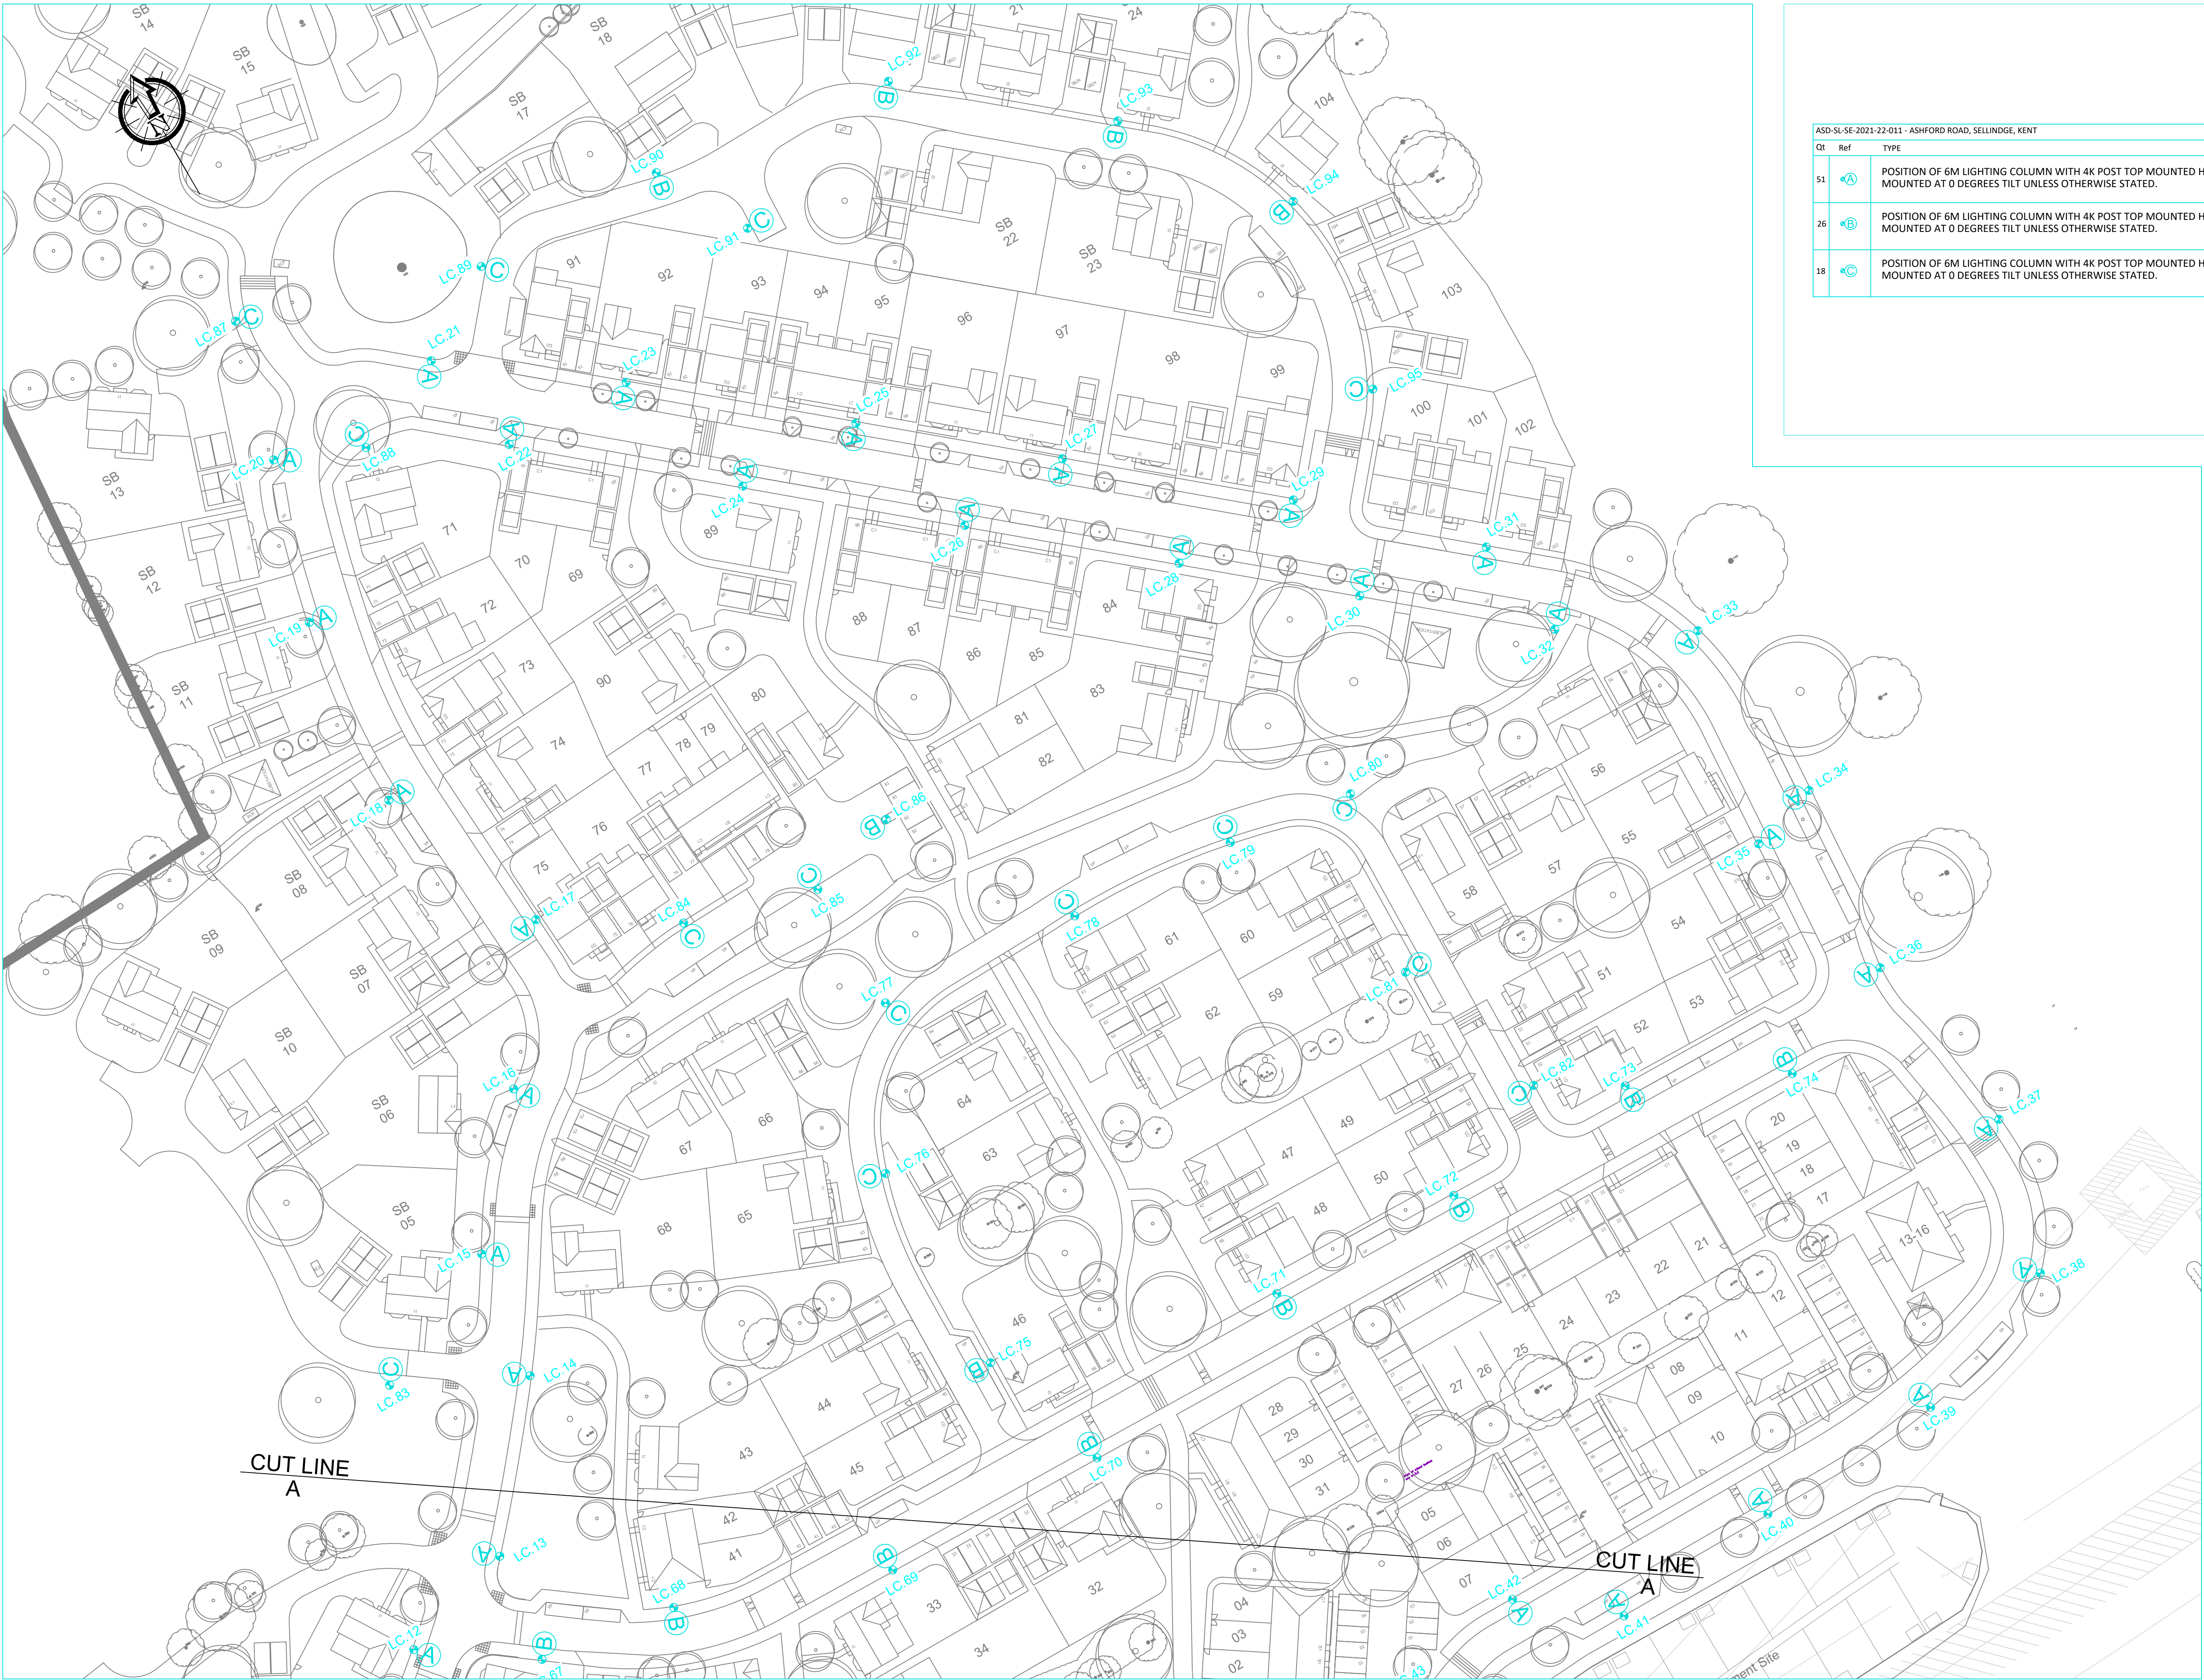

ASD-SL-SE-2021-22-011 - ASHFORD ROAD, SELLINDGE, KENT		
Qt	Ref	TYPE
51	A	POSITION OF 6M LIGHTING COLUMN WITH 4K POST TOP MOUNTED HIGHWAY DIAMOND 12 LED 500mA S4 LENS MOUNTED AT 0 DEGREES TILT UNLESS OTHERWISE STATED.
26	B	POSITION OF 6M LIGHTING COLUMN WITH 4K POST TOP MOUNTED HIGHWAY DIAMOND 12 LED 400mA S4 LENS MOUNTED AT 0 DEGREES TILT UNLESS OTHERWISE STATED.
18	C	POSITION OF 6M LIGHTING COLUMN WITH 4K POST TOP MOUNTED HIGHWAY DIAMOND 12 LED 200mA S4 LENS MOUNTED AT 0 DEGREES TILT UNLESS OTHERWISE STATED.

THE LIGHTING DESIGN HAS BEEN PREPARED IN ACCORDANCE WITH BS5489_2015 TO PROVIDE INDICATIVE COLUMN POSITIONS. FOR TRANSPARENCY AND THE AVOIDANCE OF DOUBT DRAWING no. ASD-SL-SE-2021-22-011 IS NOT TO BE USED AS A CONSTRUCTION DRAWING. A SITE SURVEY HAS NOT BEEN CARRIED OUT IN ACCORDANCE WITH CDM 2015 AND HEA GUIDELINES. THEREFORE THE RESPONSIBILITIES OF ELIMINATING AND REDUCING RISK WILL NEED TO MITIGATED BY A COMPETENT PRINCIPLE DESIGNER.

REV	DESCRIPTION	DATE	BY
			
ASD LIGHTING PLC MANGHAM ROAD BARBOT HALL INDUSTRIAL ESTATE ROTHERHAM S61 4RJ			
TITLE STREET LIGHTING LAYOUT PROPOSED DEVELOPMENT ASHFORD ROAD SELLINDGE KENT SHEET 2 OF 2			
CUSTOMER KENT COUNTY COUNCIL			
SCALE	DATE	27/01/22	
1:500	DRAWN	BJS	
	CHECKED	MDE	
PAPER SIZE	A1	APPROVED	NF
DRAWING NUMBER	REVISION		
ASD-SL-SE-2021-22-011	R0		